


15240 [50']

LEGEND	
SYMBOL	DESCRIPTION
	CEILING TUBE LIGHT + BATTEN HOLDER
	WALL TUBE LIGHT + BATTEN HOLDER
	WALL CFL + BATTEN HOLDER
	CEILING CFL + BATTEN HOLDER
	STREET LIGHT FITTING
	BULK HEAD FITTING
	CEILING FAN + REGULATOR
	EXHAUST FAN + CEILING ROSE
	15A UNIVERSAL SOCKET+ 15A SWITCH
	32A DP SWITCH
	6A 3PIN SOCKET WITH SWITCH ON RAW POWER
	6A 3PIN SOCKET WITHOUT SWITCH ON RAW POWER
	1NO. 6A 3PIN SOCKET WITH SWITCH ON UPS
	DATA POINT
	TELEPHONE POINT
	TV POINT
	CCTV
	5A SWITCHES
	2 WAY SWITCHES
	MIRROR LIGHT FIXTURE
	UPS DISTRIBUTION BOARD
	LIGHTING POWER DISTRIBUTION BOARD
	MAIN DISTRIBUTION BOARD
	EARTHING
	8SWG GI WIRE
	GI PIPE

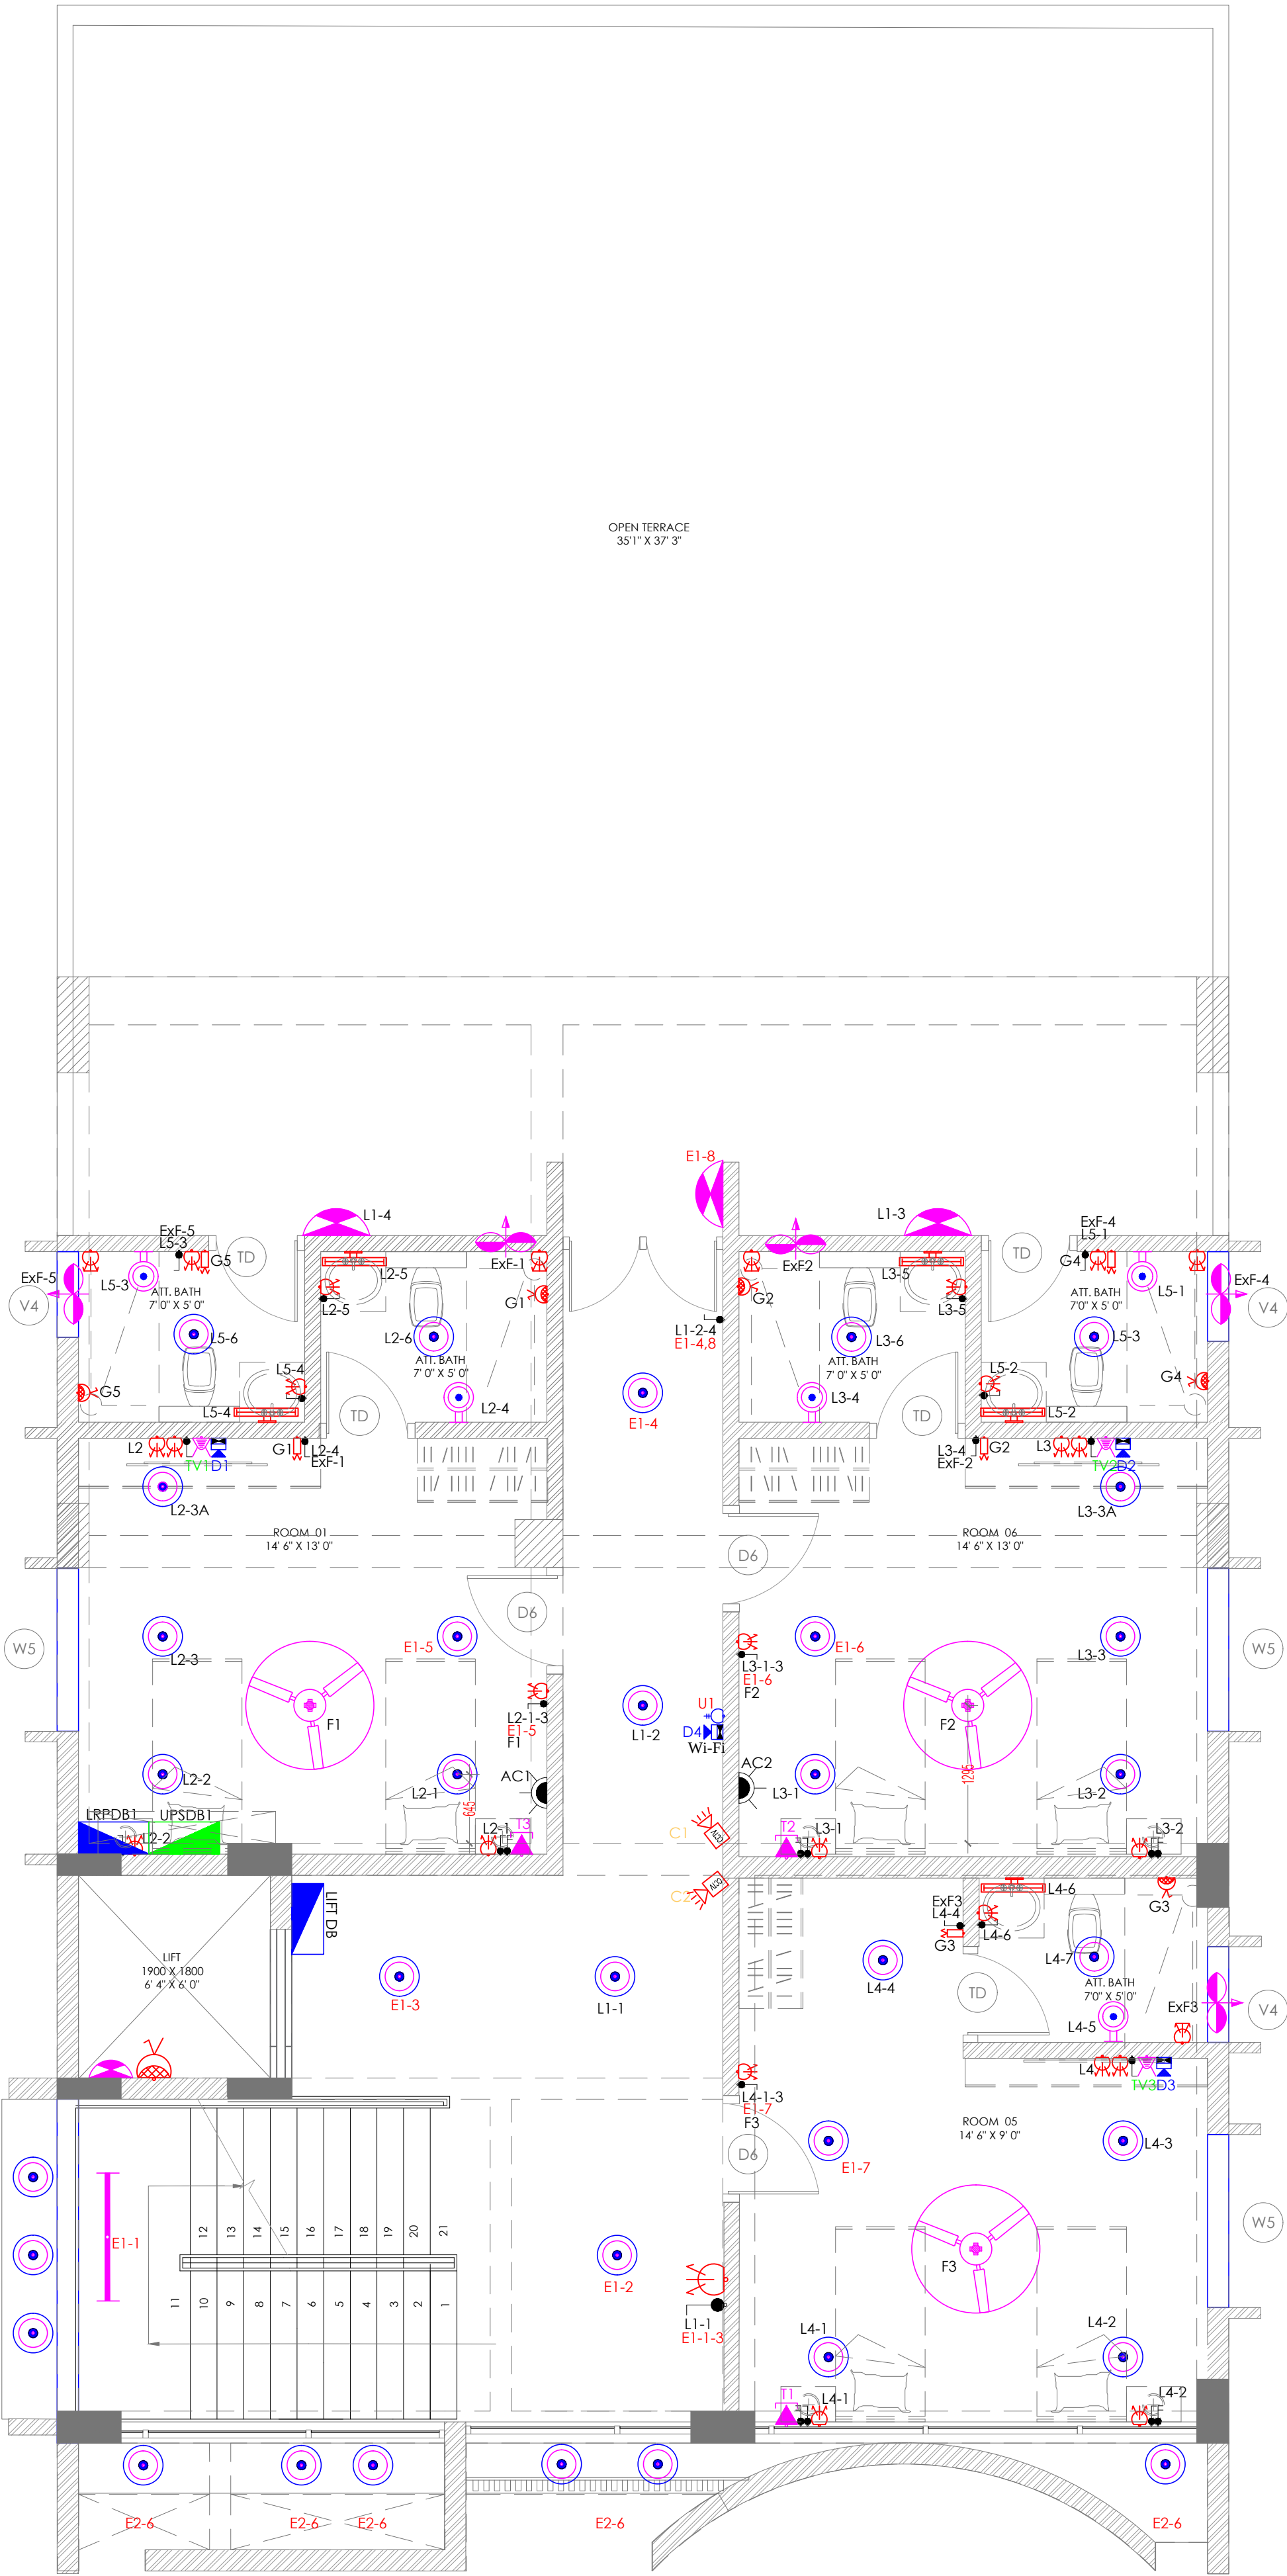

30480 [100']

12 METER ROAD

R1

NOTE:		LEGEND / SYMBOLS		WIRING		SCALE		Not To Scale		SHEET SIZE		A1		DRAWING TITLE		ELECTRICAL LAYOUT	
1. THE DESIGN & DRAWING IS THE PROPERTY & COPYRIGHT OF M/s. MYRIAD GEOMETRIES/MG10 ARCHITECTURE. REPRODUCTION AND USE OF THE DESIGN, IN WHOLE OR IN PART, IS FORBIDDEN WITHOUT THE ARCHITECT'S WRITTEN CONSENT. 2. DRAWING IS NOT TO BE SCALED. 3. ALL DIMENSIONS ARE IN MILLIMETERS AND LEVELS IN METERS UNLESS NOTED OTHERWISE. 4. ANY DISCREPANCIES IN THE DRAWING SHALL BE BROUGHT TO THE NOTICE OF THE ARCHITECT BEFORE EXECUTION. ALL DIMENSIONS TO BE VERIFIED ON SITE AND APPROVED BY THE ARCHITECT/PROJECT MANAGER. 5. DRAWING SHOULD BE READ IN CONJUNCTION WITH OTHER RELEVANT ARCHITECTURAL, STRUCTURAL, MECHANICAL AND ELECTRICAL DRAWINGS AND ALL RELEVANT SECTIONS OF THE SPECIFICATIONS.		1.LEVELS IN PLANS/ELEVATIONS/SECTIONS				DATE		03 JUN 2026						SECOND FLOOR PLAN LGT/EMG CIRCUIT LAYOUT		REV NO	
		 FINISHED FLOOR LEVEL  STRUCTURAL SLAB LEVEL				DRAWN		RAGHU								R0	
		 FORMATION GROUND LEVEL				CHECKED		RAGHU									
		2.DOORS		DOOR TYPES DRAWING NUMBERS				SIGNATURE		-							
		3.SECTIONS		SECTION NUMBERS DRAWING NUMBERS				PROJECT:		PROPOSED COMMERCIAL DEVELOPMENT FOR KSSFCL at Vishveshwar Nagar, Mysuru - 570008				CLIENT:		KARNATAKA STATE SOUHARDA FEDERAL CO-OPERATIVE LTD. Margosa Road,Mallathuram, Bengaluru - 560003	
						STRUCTURAL CONSULTANT :		 NESTA PROJECTS Shivamogga				MEP CONSULTANT :		M/s GR ENGINEERS Bengaluru			
														ARCHITECTS		 MYRIAD ARCHITECTS IN PRACTICE BANGALORE	